




FESTOON LIGHTS
WARM WHITE LED LAMPS
SPACED 50CM APART
0.35W (20LUMENS) PER LAMP



INDIAN SANDSTONE PAVING



RESIN BOUND GRAVEL

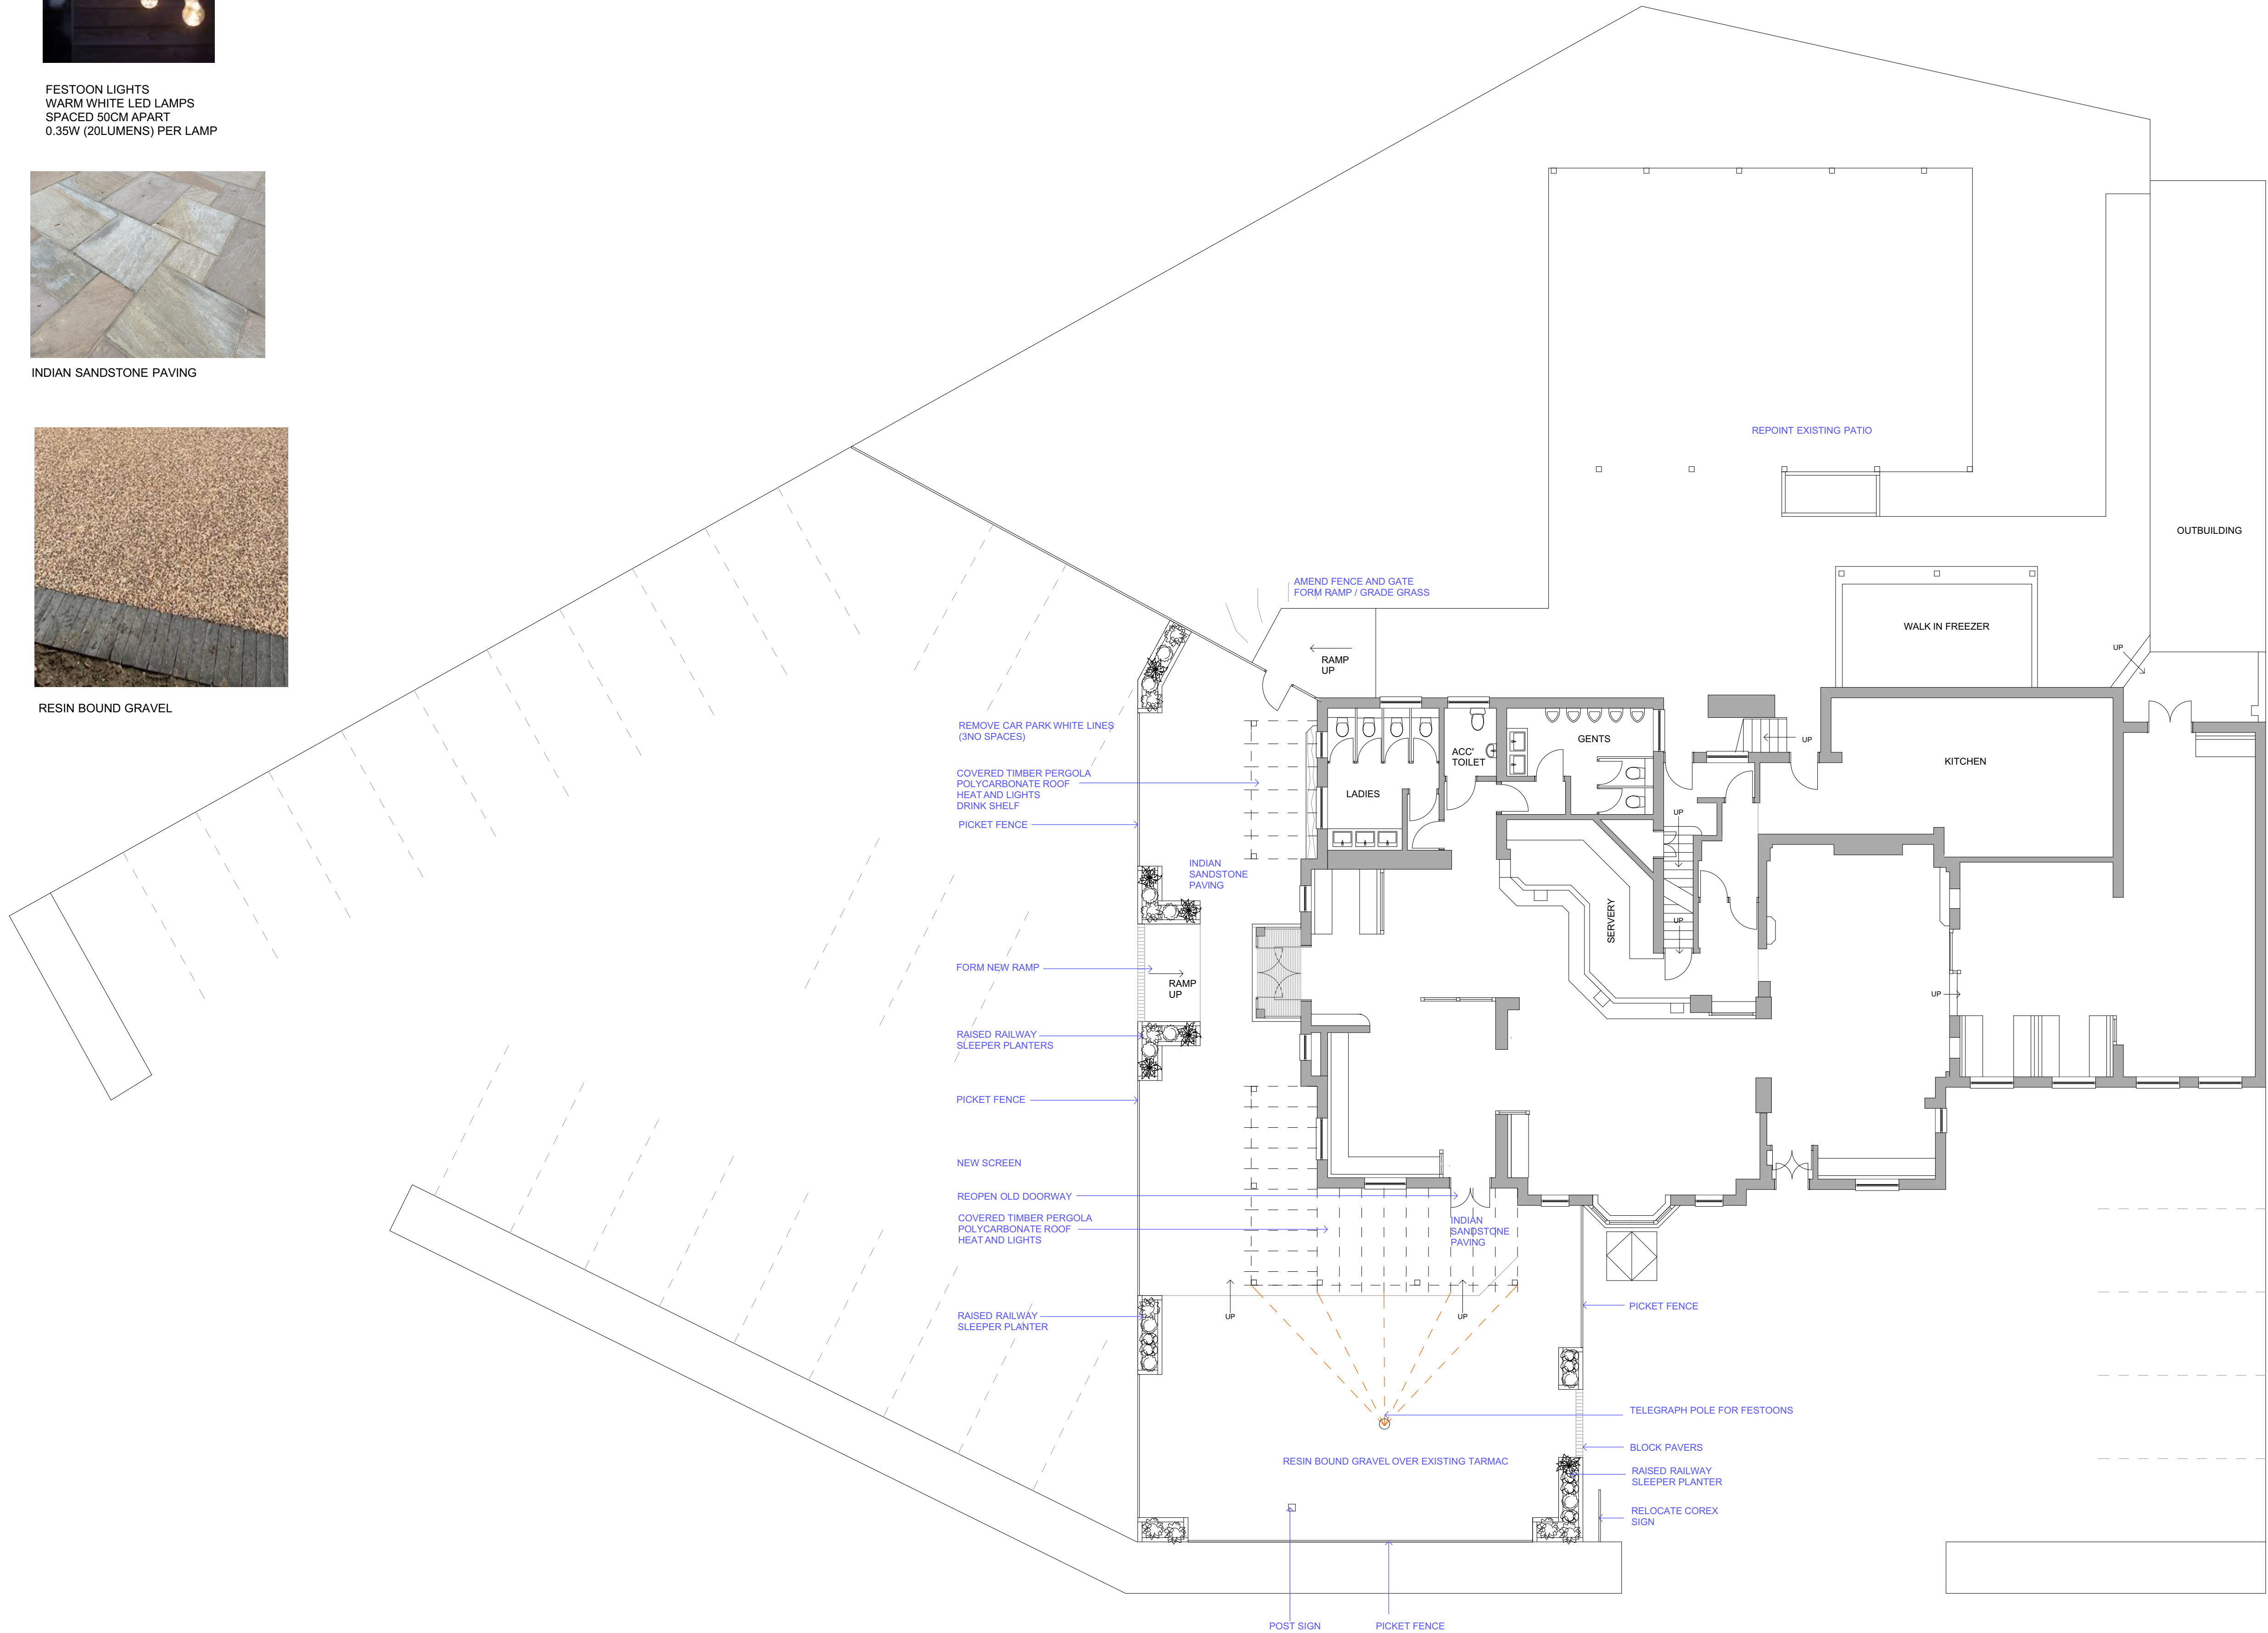

SITE PLAN AS PROPOSED



ARC design consultants ltd
18 sunningdale,orton waterville
peterborough pe2 5up
tel: 01733 234857
e-mail: jane@arcdesign.co.uk

CLIENT
GREENE KING

PROJECT
THE WATER TOWER
READING

DRAWING
SITE PLAN AS PROPOSED

DATE JANUARY 2026
SCALE 1:100 @ A1
DRAWN BY JLC
PROJECT NO GK 353
DRAWING NO 04

This drawing is the property of
ARC Design Consultants Ltd.
Copyright is reserved by them and the drawing
is issued on the condition that it is not copied
without their written consent or if it is used without the written
consent of ARC Design Consultants Ltd.
Do not scale from this drawing.
Use figured dimensions only.
All dimensions to be checked on site before
commencement of any work and on shop drawing.
This is to be read in conjunction with all the
relevant design and construction drawings
and schedule of works.