


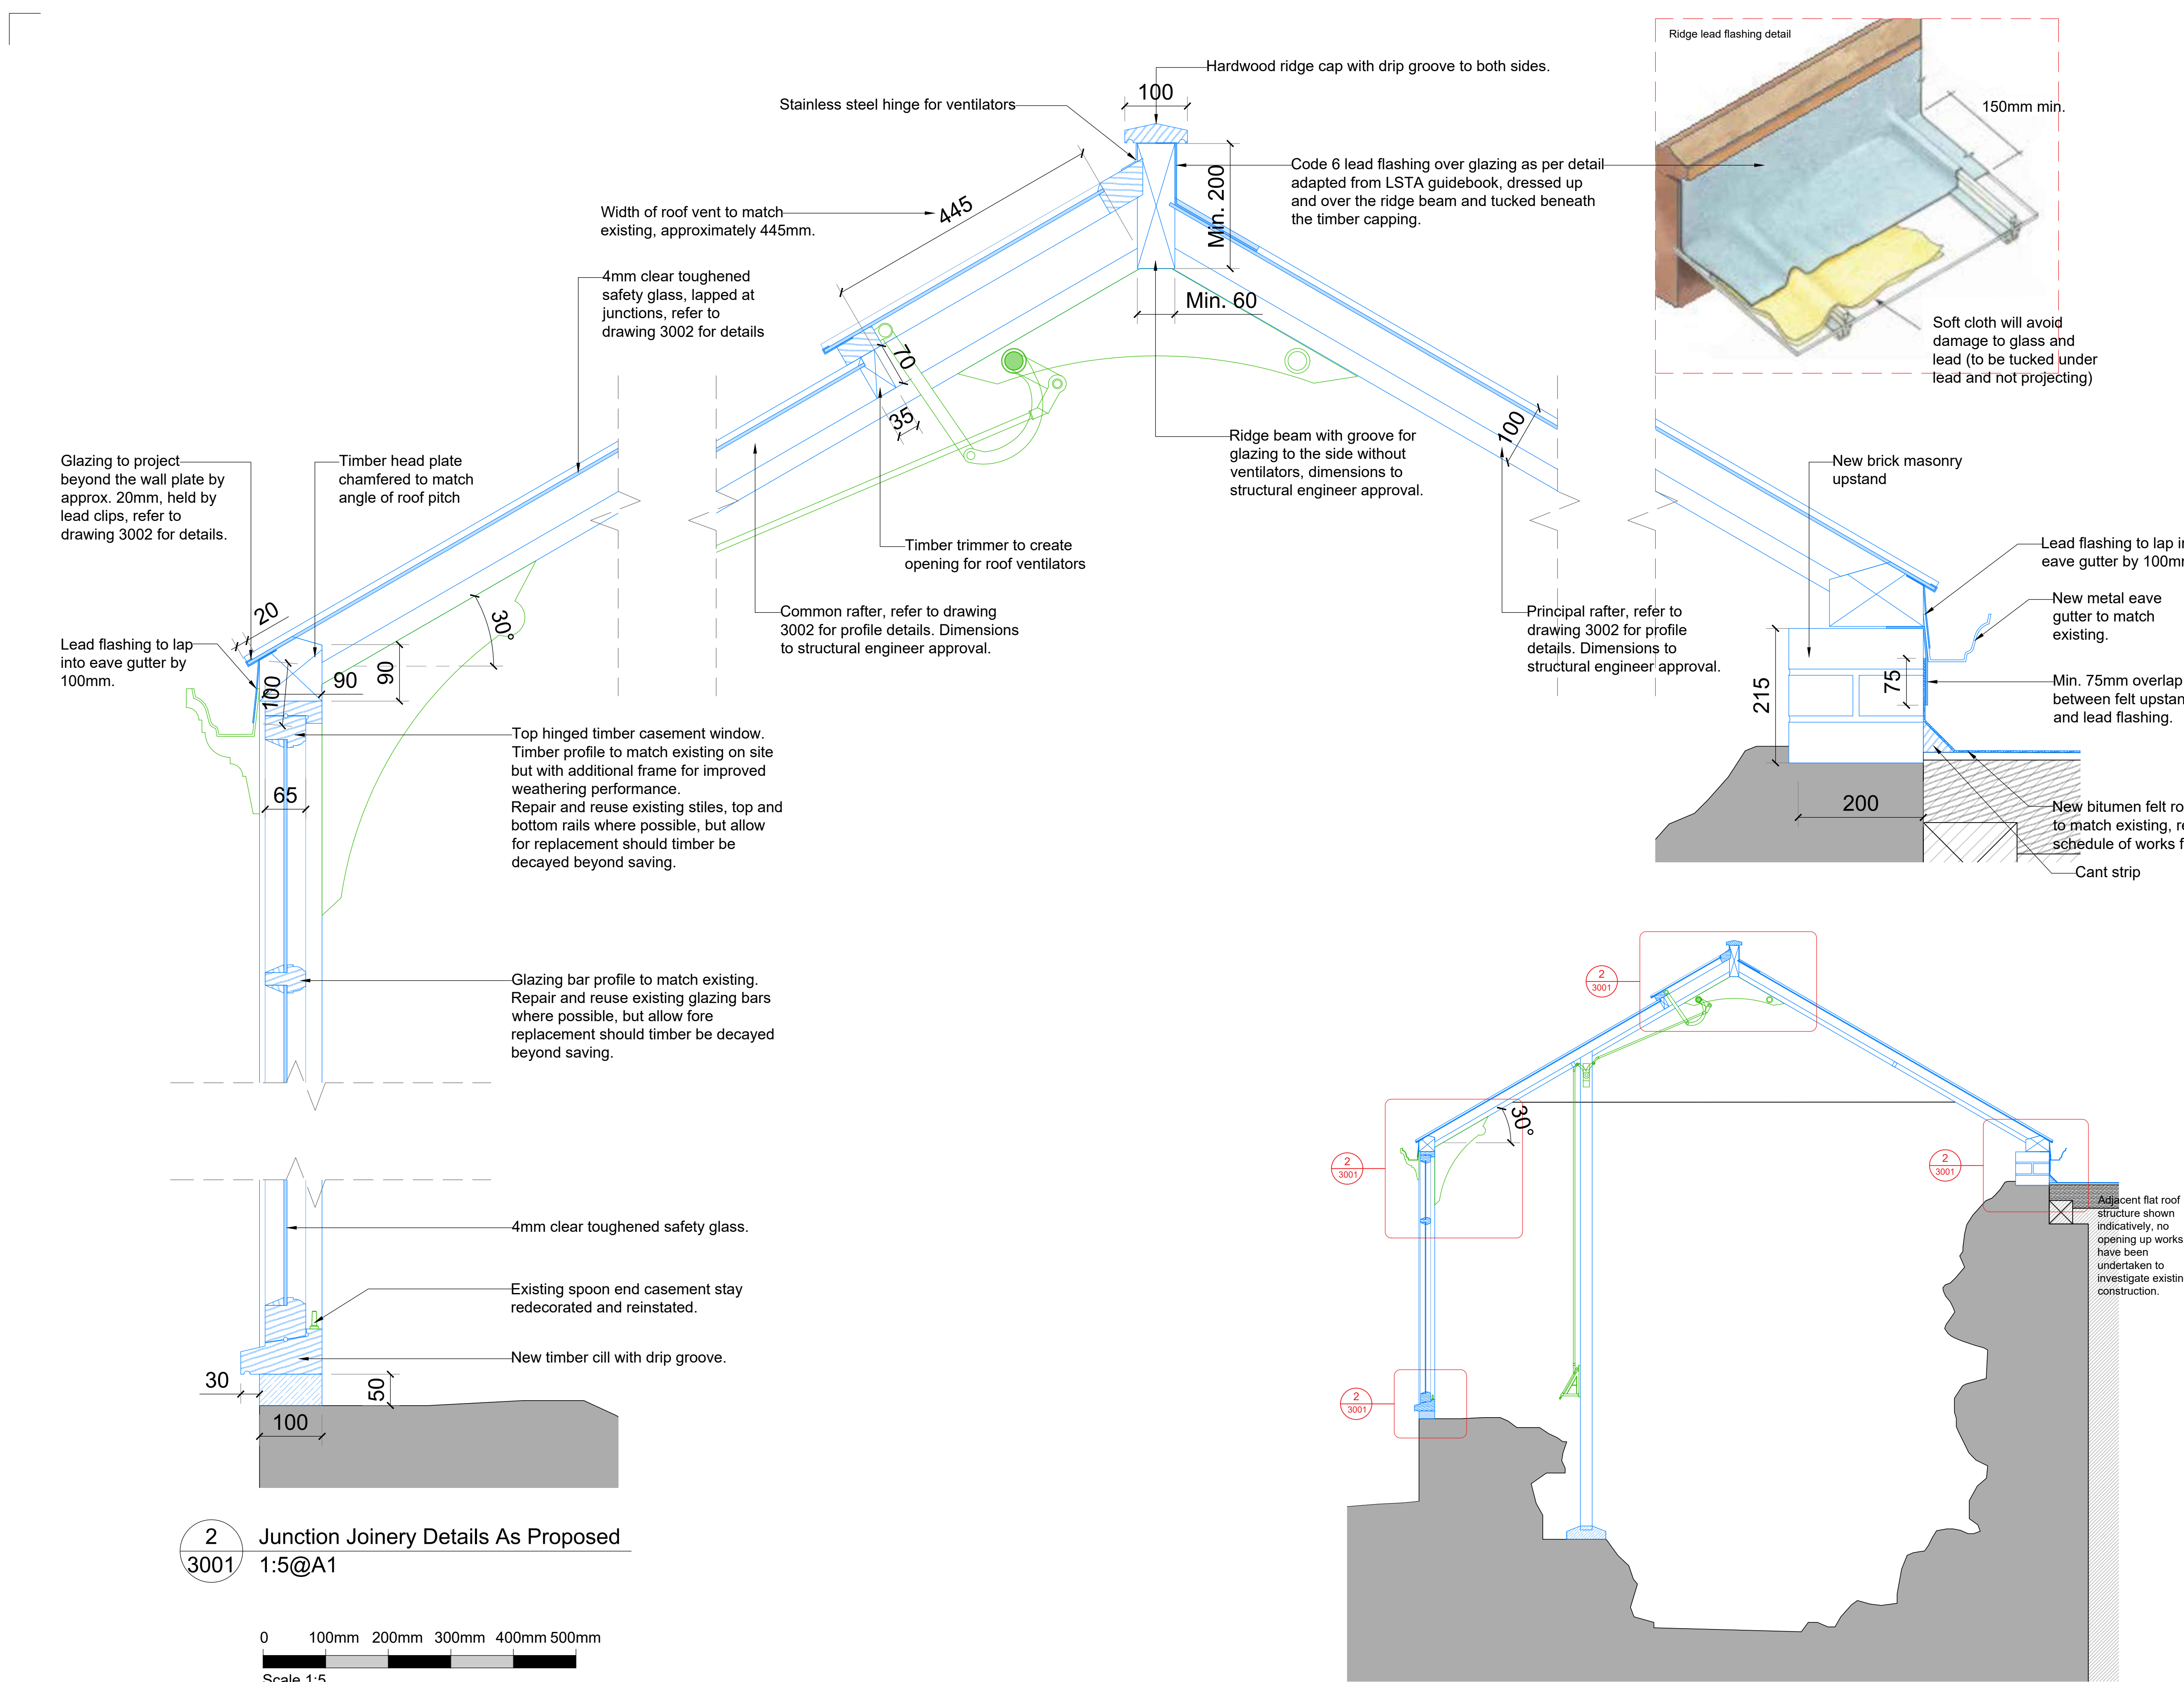

Notes:
Drawings are based on survey data however any discrepancies should be notified to Purcell in writing.

Due to the scales used any measurements from this drawing should include an appropriate level of tolerance.
Where appropriate site dimensions should be taken to verify accuracy of measurement.

All dimensions are in millimetres unless noted otherwise.

Purcell shall be notified in writing of any discrepancies.

The digital content in this DWG file is the property of Purcell Architecture Limited and is shared for information only. Do not copy, share, or reuse any part of it without our written permission.

Key Plan
not to scale

Roof plan

Proposed new elements / replacements

Proposed repairs & reinstatement

Refer to drawing 3005 for metalwork repair requirements.

C01	19.02.2026	AW	WH	For LBC Condition Discharge
REV	DATE	BY	CHK	DESCRIPTION

CLIENT
University of Reading

PROJECT
The Fernery at the Acacias

JOB NUMBER
242925

TITLE
Joinery Details 1

SIZE
A1L


SCALE
As Indicated

REV
C01 A3 - For LBC Condition Discharge

DRAWING NUMBER
242925-PUR-01-XX-DR-A-3001

PURCELL® IS THE REGISTERED TRADE NAME FOR PURCELL ARCHITECTURE LTD AND ALL SUBSIDIARY COMPANIES AND IS REGISTERED IN THE UNITED KINGDOM, EUROPEAN UNION, HONG KONG, CHINA AND AUSTRALIA
© PURCELL 2026, purcellarchitecture.com

2
3001 Junction Joinery Details As Proposed
1:5@A1

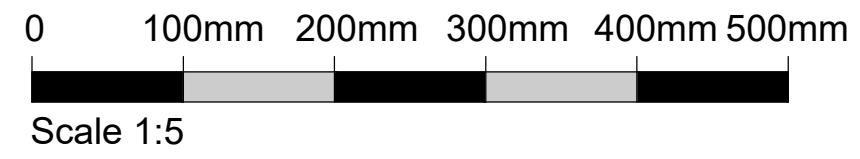

1
3001 Section As Proposed
1:20@A1

