




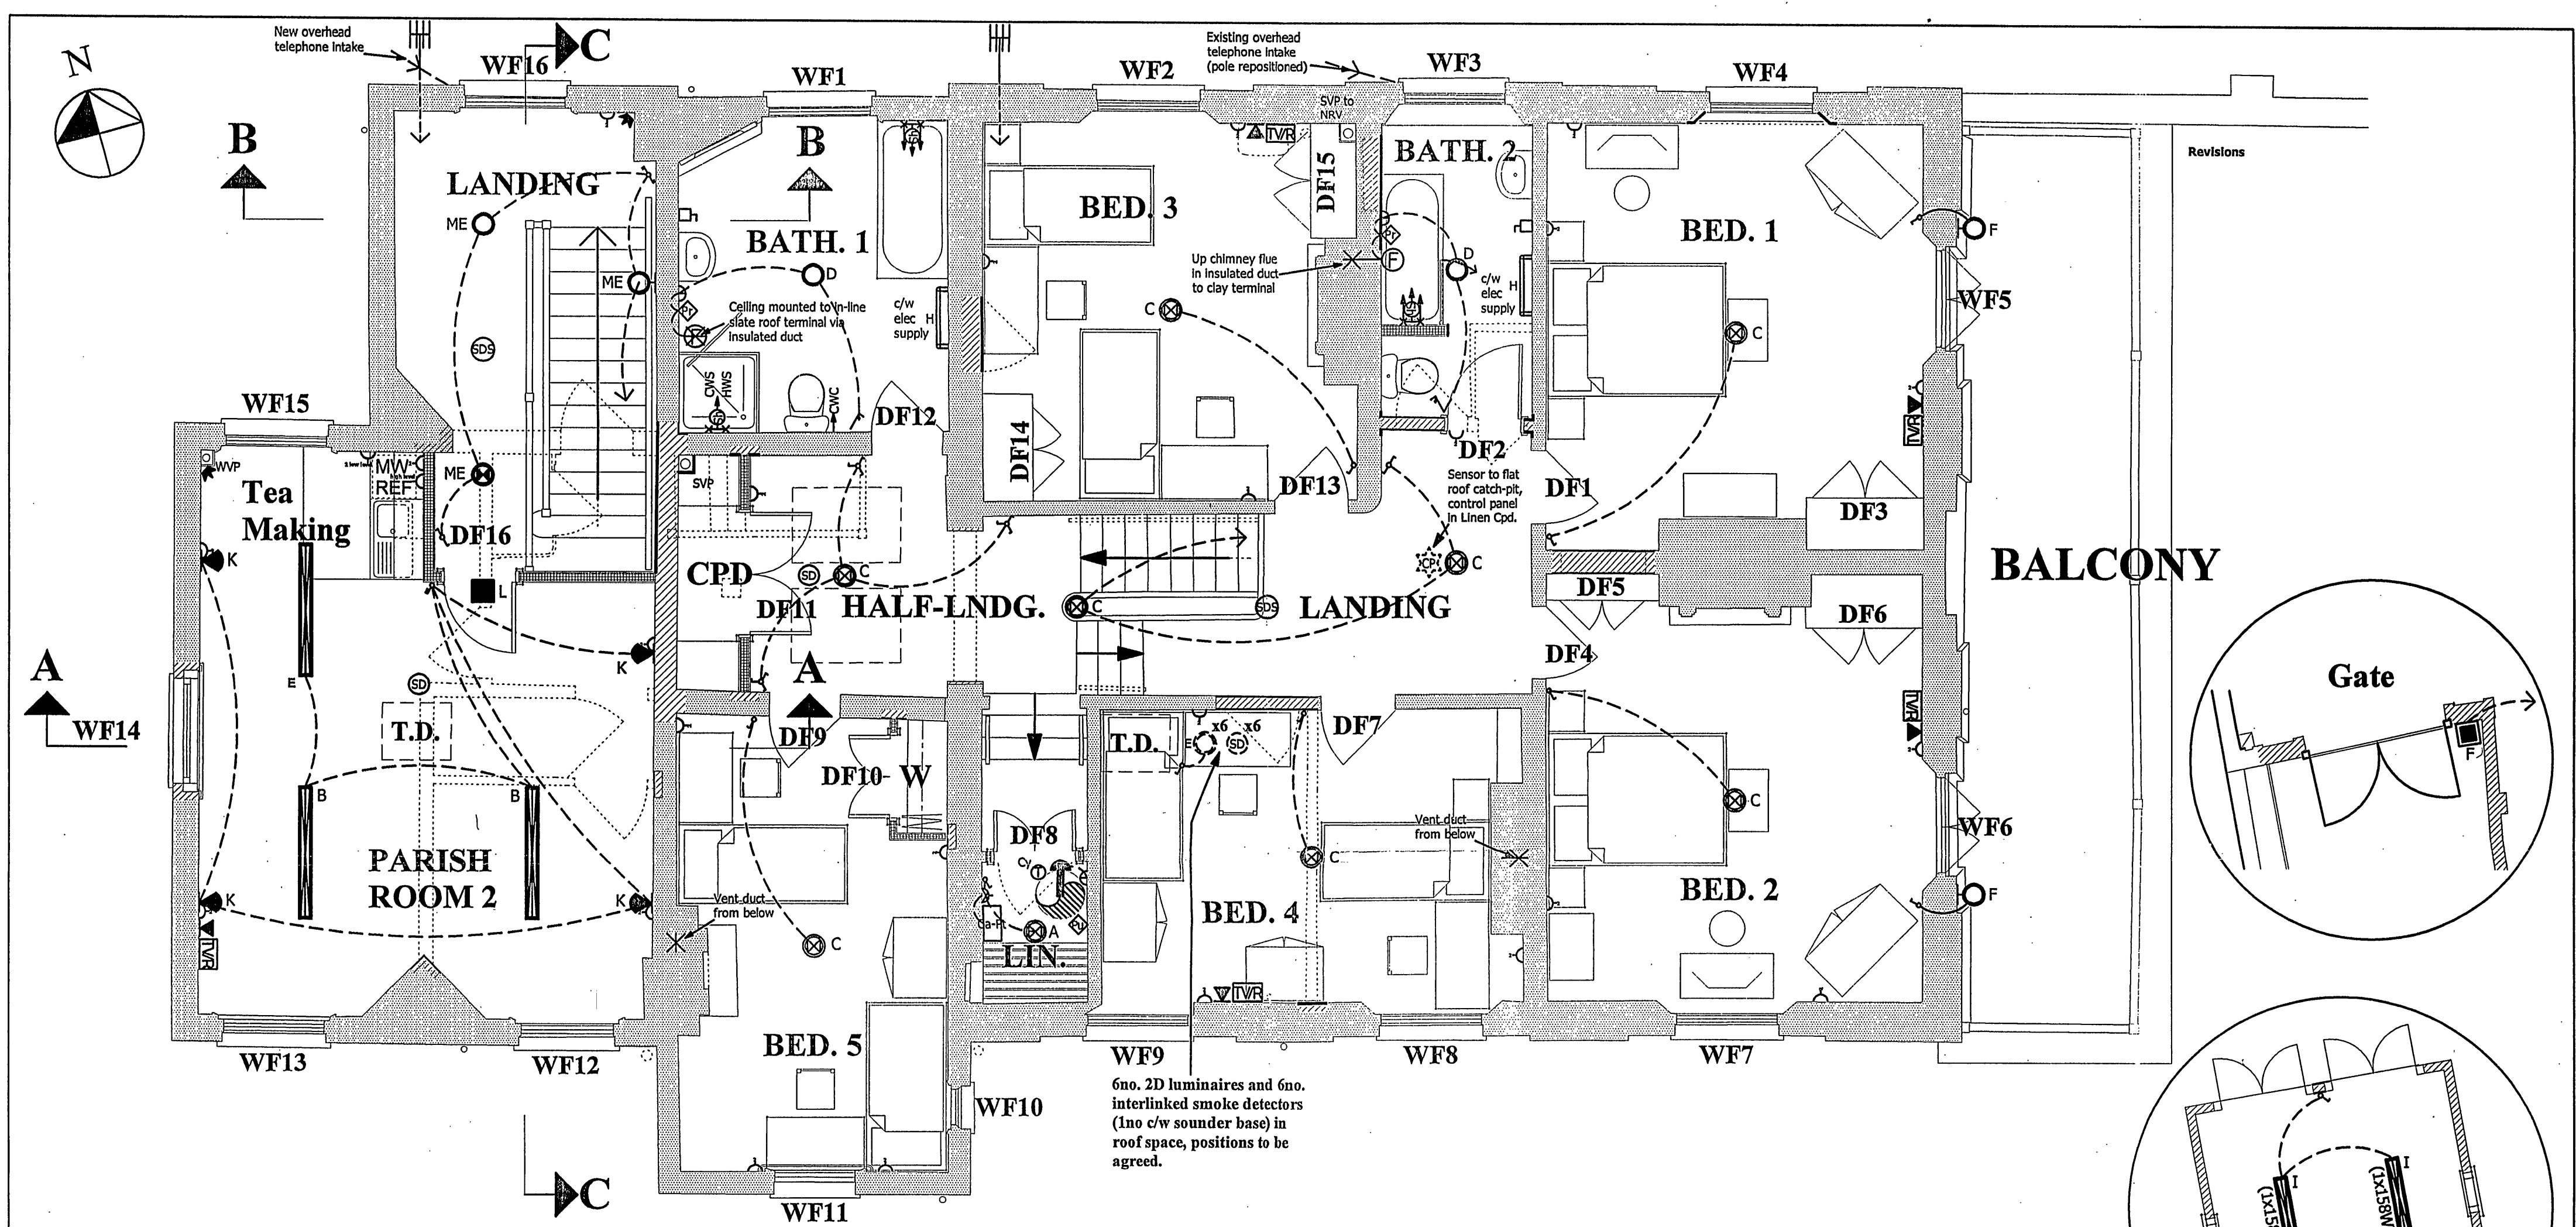

FIRST FLOOR PLAN

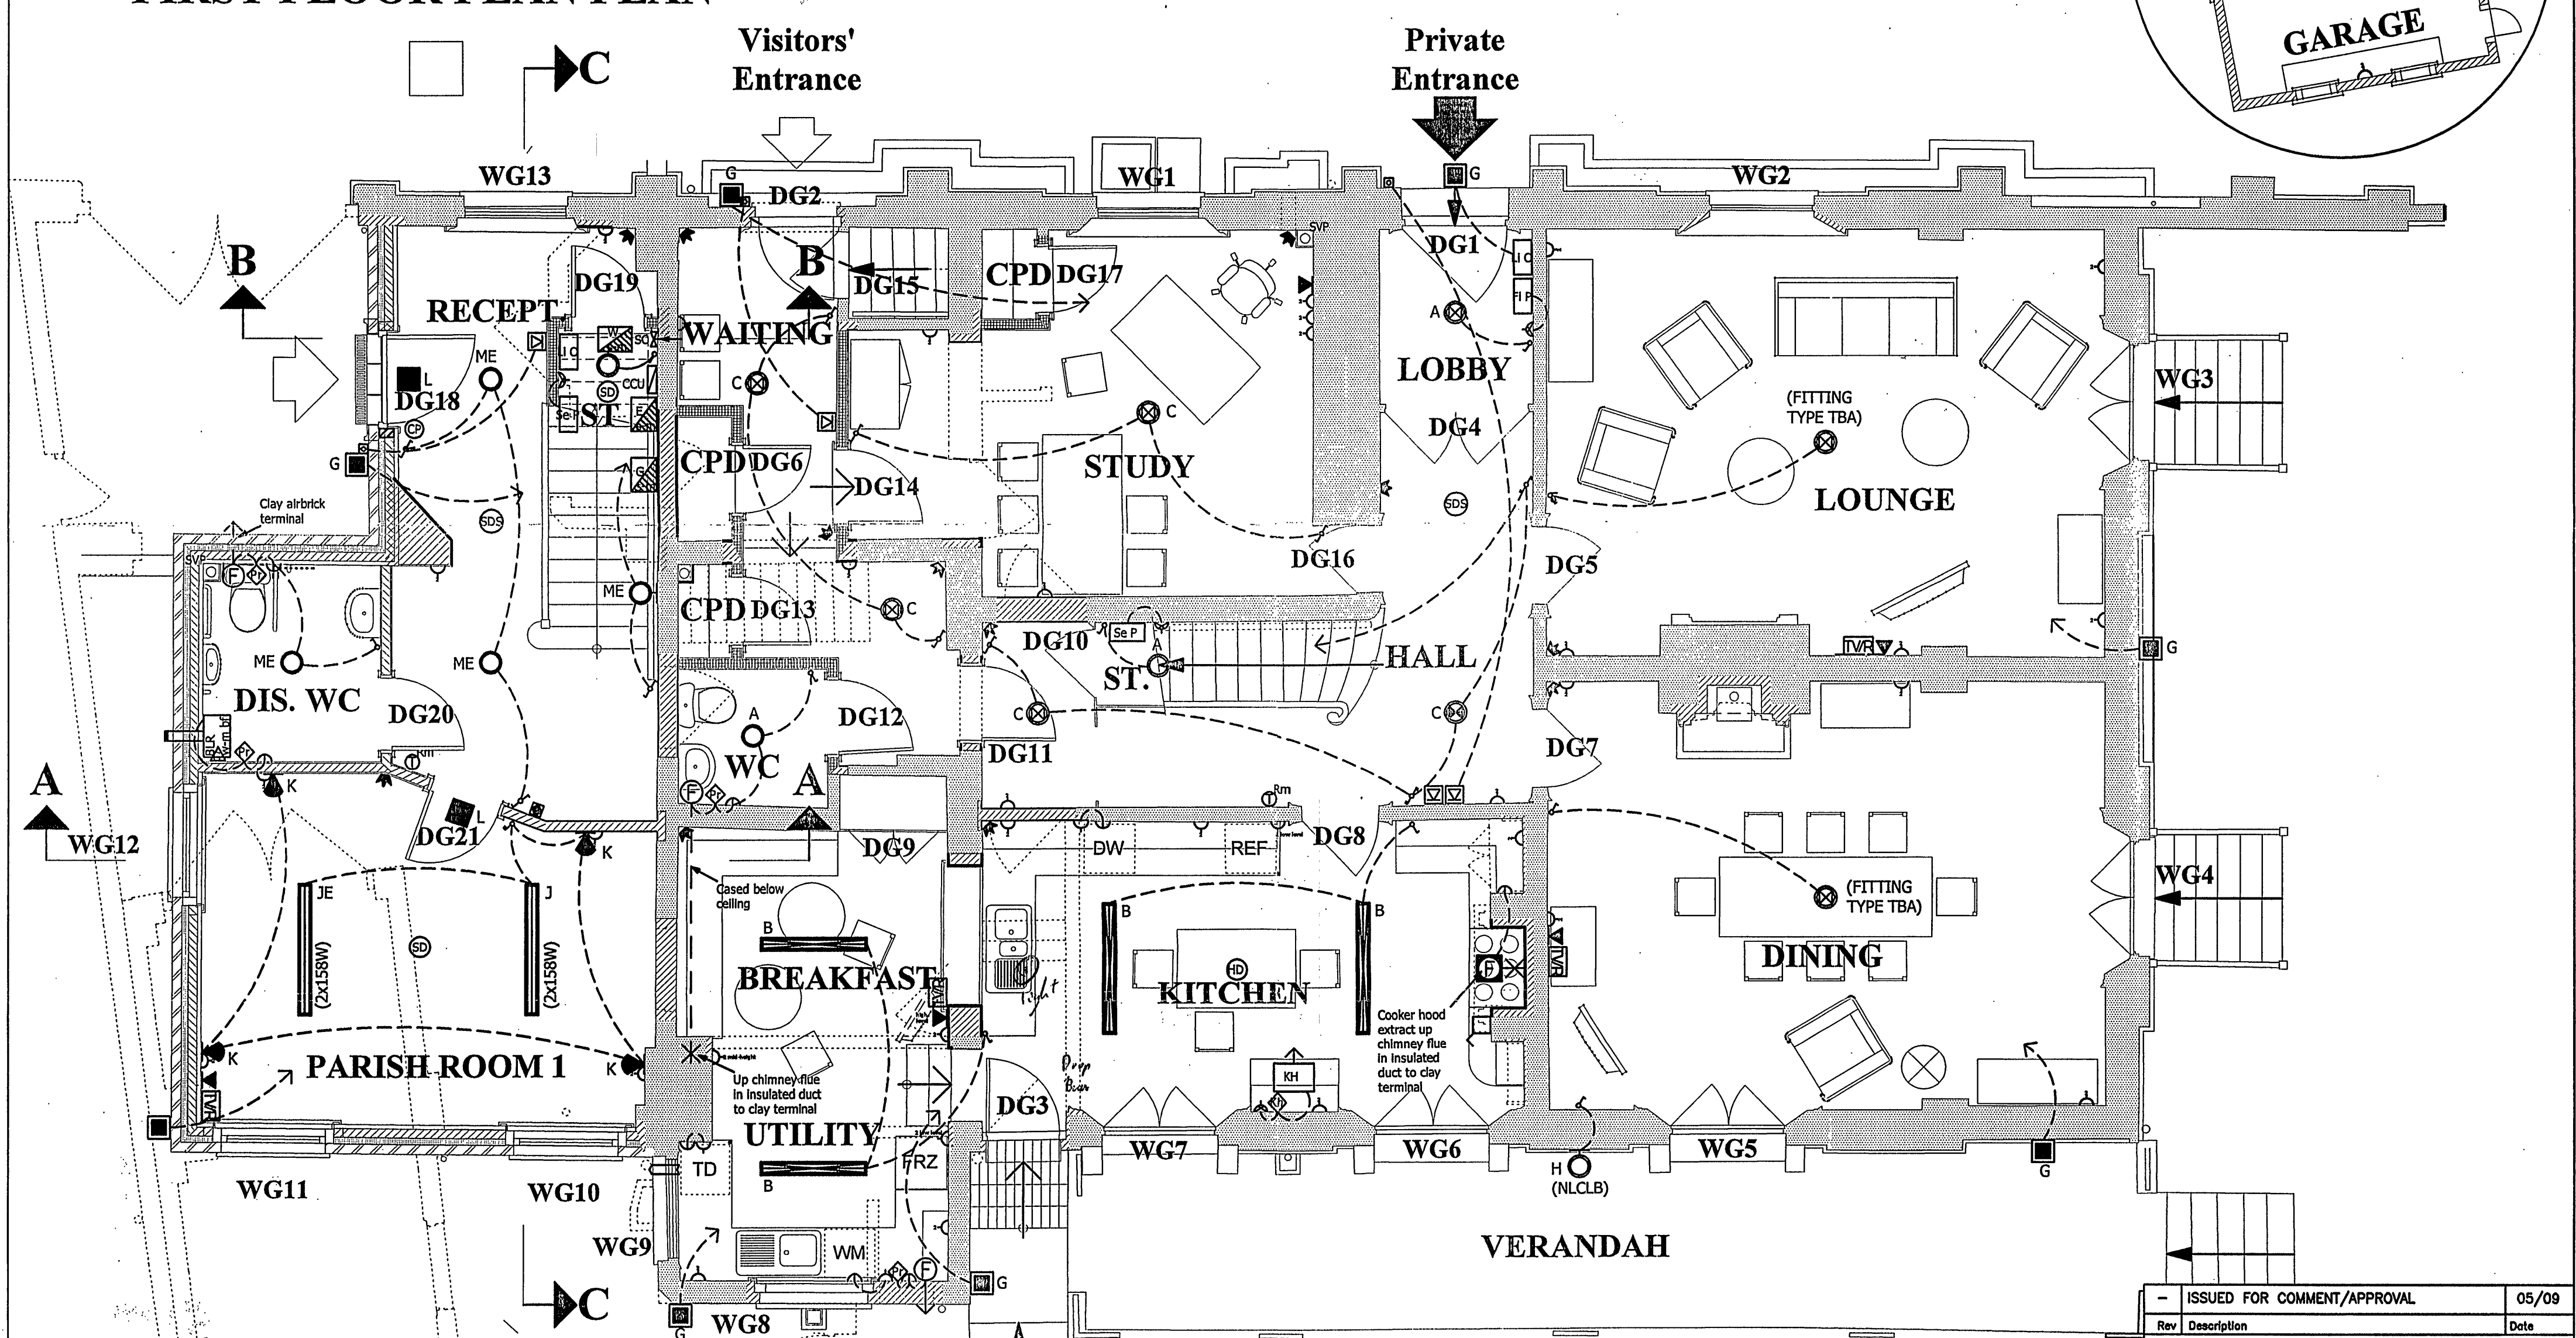

GROUND FLOOR PLAN

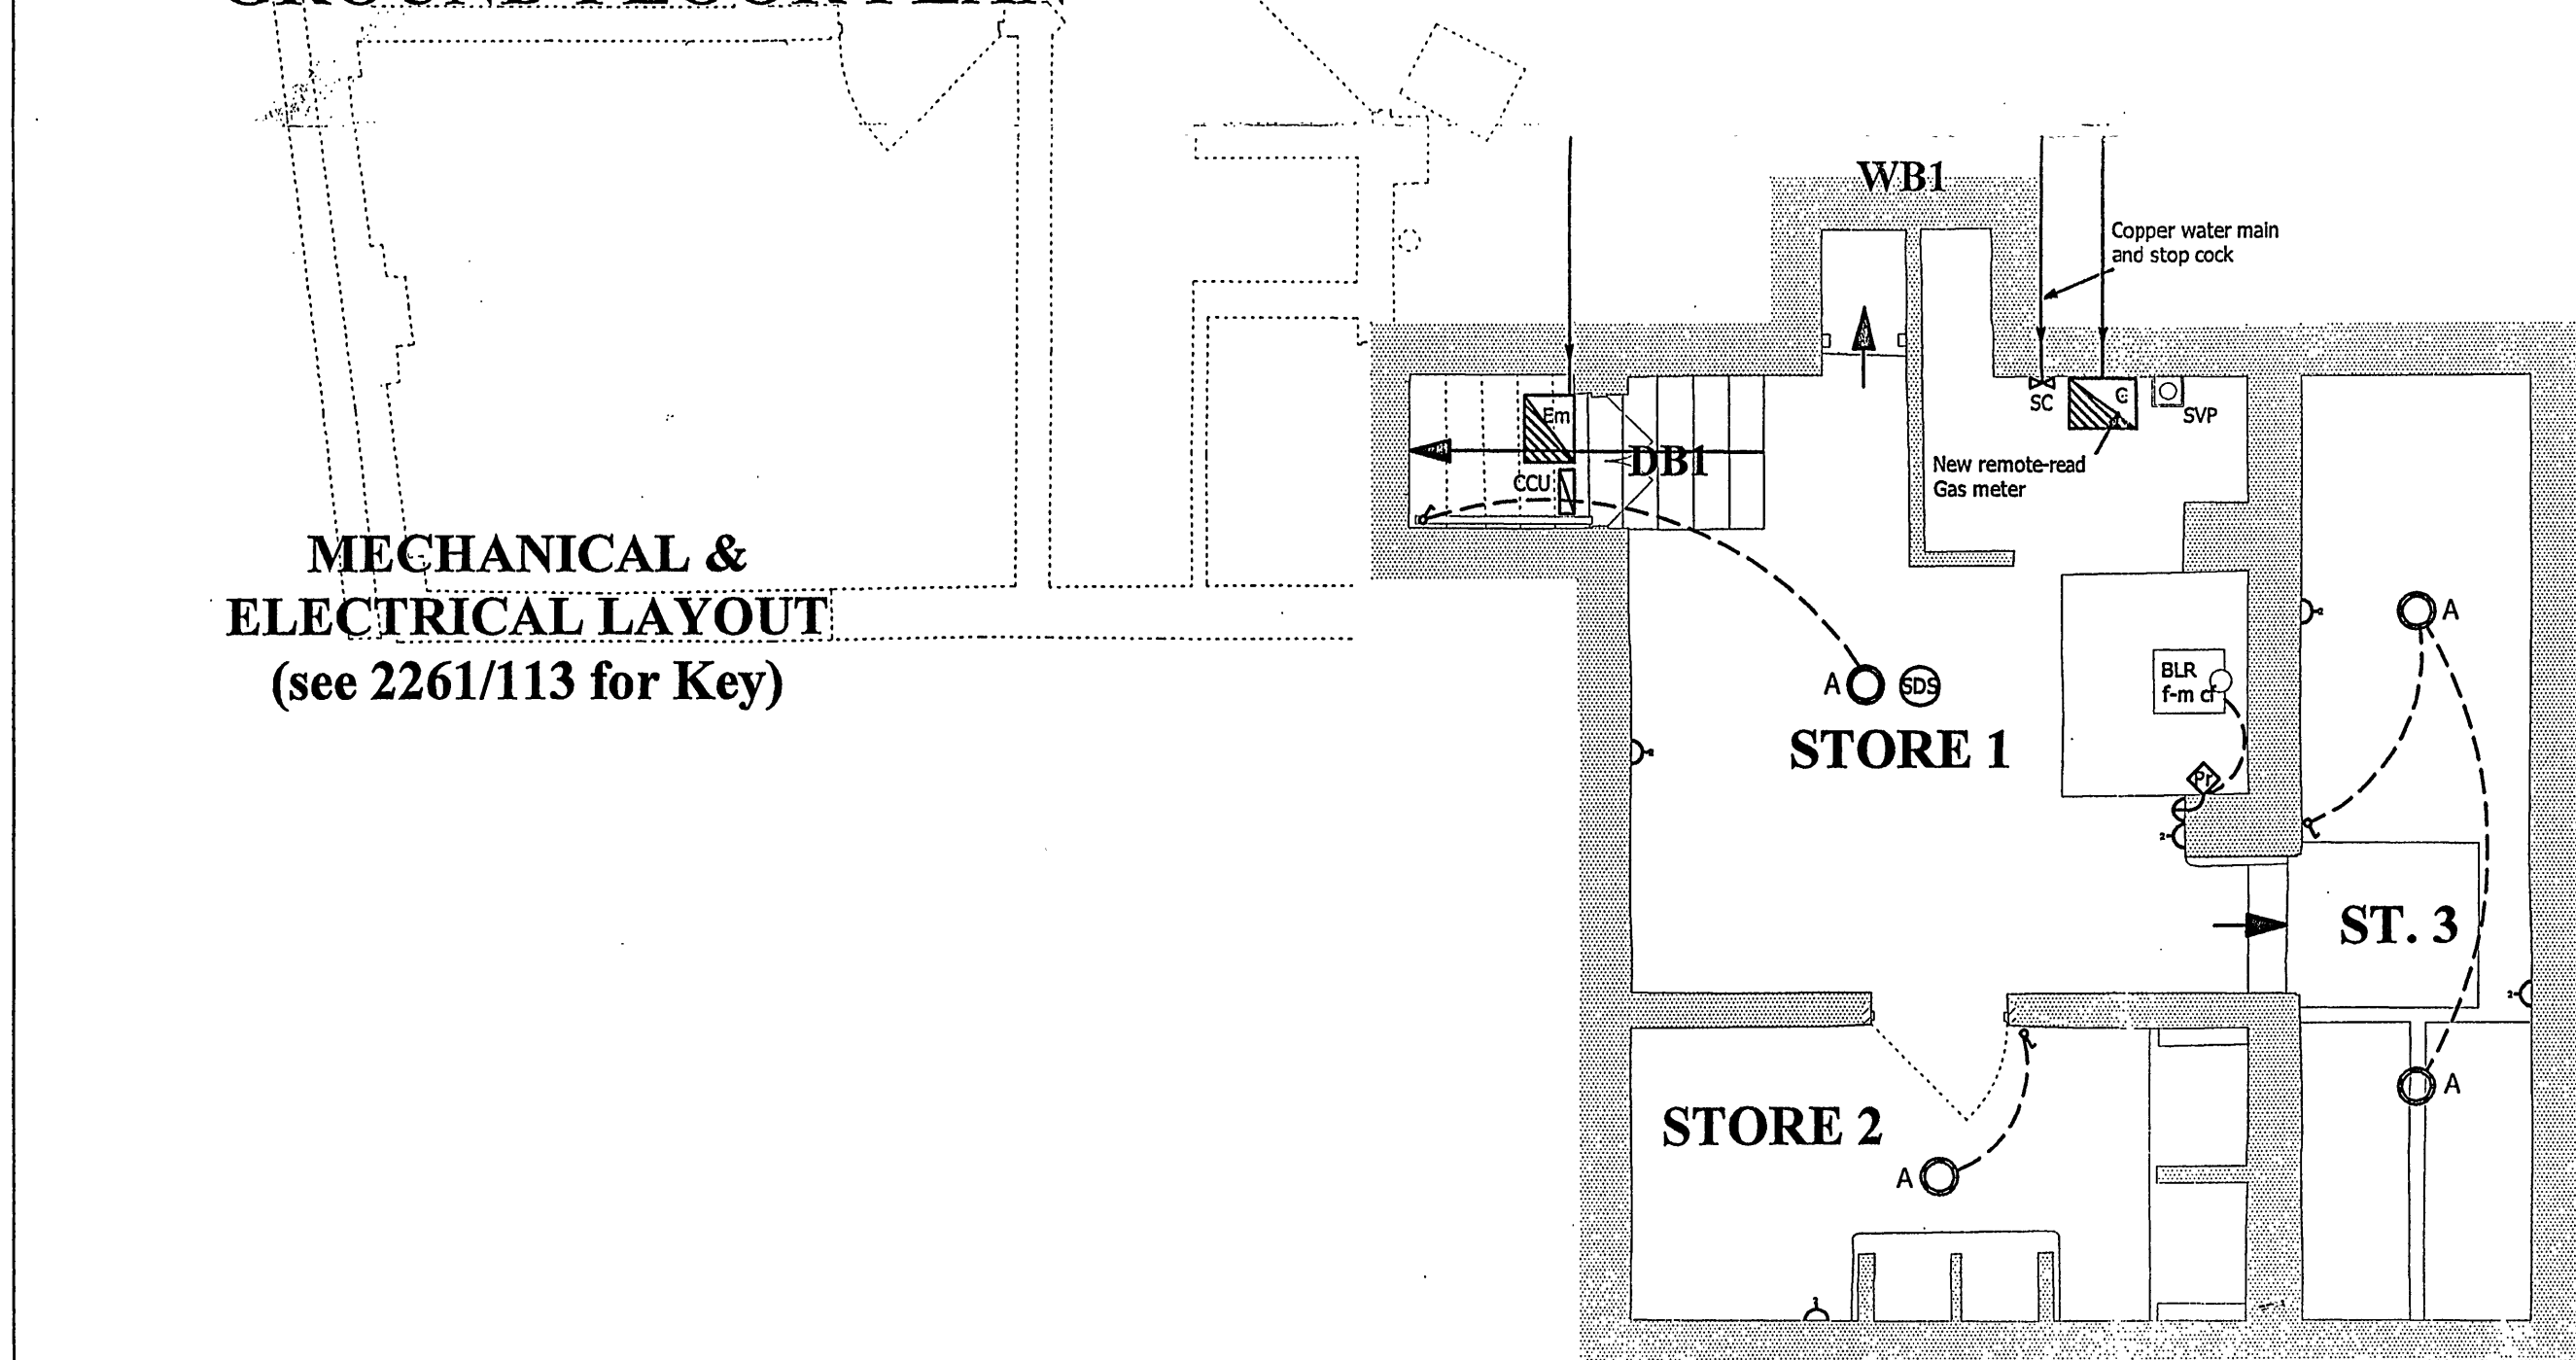

BASEMENT PLAN


 
MECHANICAL & ELECTRICAL LAYOUT
(see 2261/113 for Key)

Key

Existing

New

Demolished

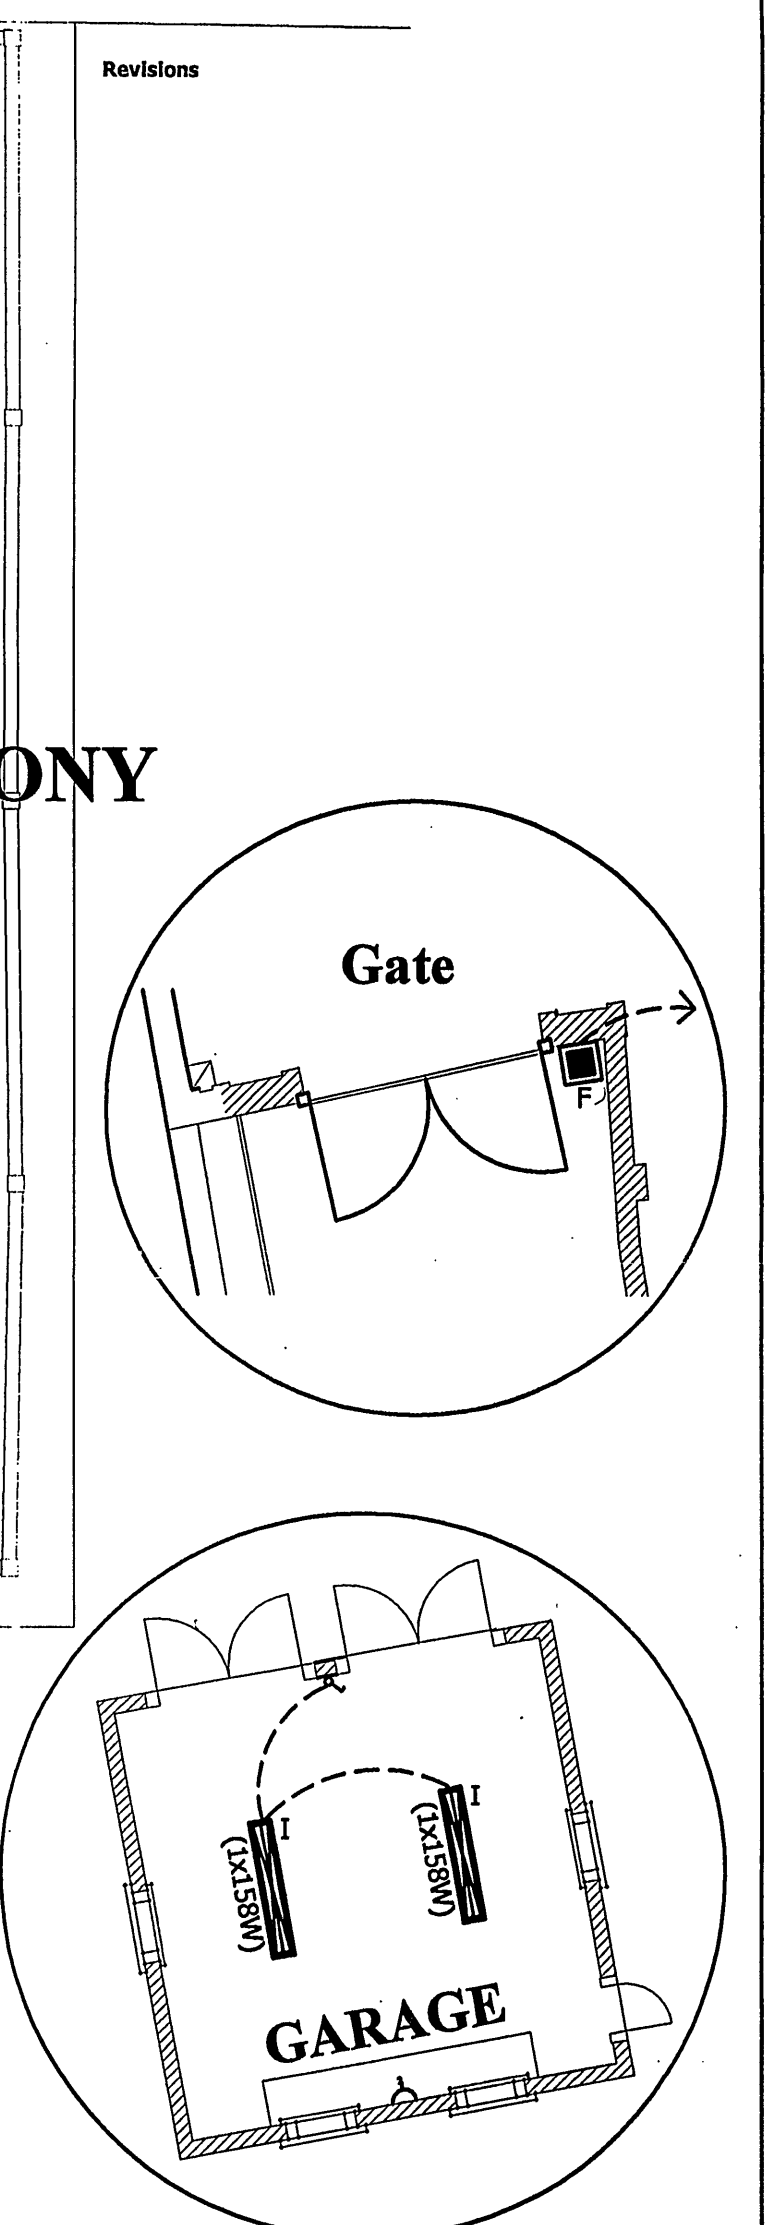

ISSUED FOR COMMENT/APPROVAL		05/09
Rev	Description	Date
Revision		
Client		
FRANCIS CONSTRUCTION		
Project		
DEVELOPMENT AT CAVERSHAM RECTORY, CHURCH ROAD CAVERSHAM, READING.		
Drawing Title		
FLOOR PLANS ELECTRICAL SERVICES		
WORKING DRAWING		
Drawing No.	Scale	
B1037-E02	1:50 @ A1	
Drawn	Checked	Date
ncb	JG	May 2009
Rev.		
-		
entric services		
ELECTRICAL CONTRACTORS		
Entric Services Ltd.		
Victoria Court, 64 Victoria Road, Mortimer, Reading, Berks. RG7 3SG.		
Tel: (0118)9331563 Fax: (0118)9331564 Email: headoffice@entric.co.uk		