



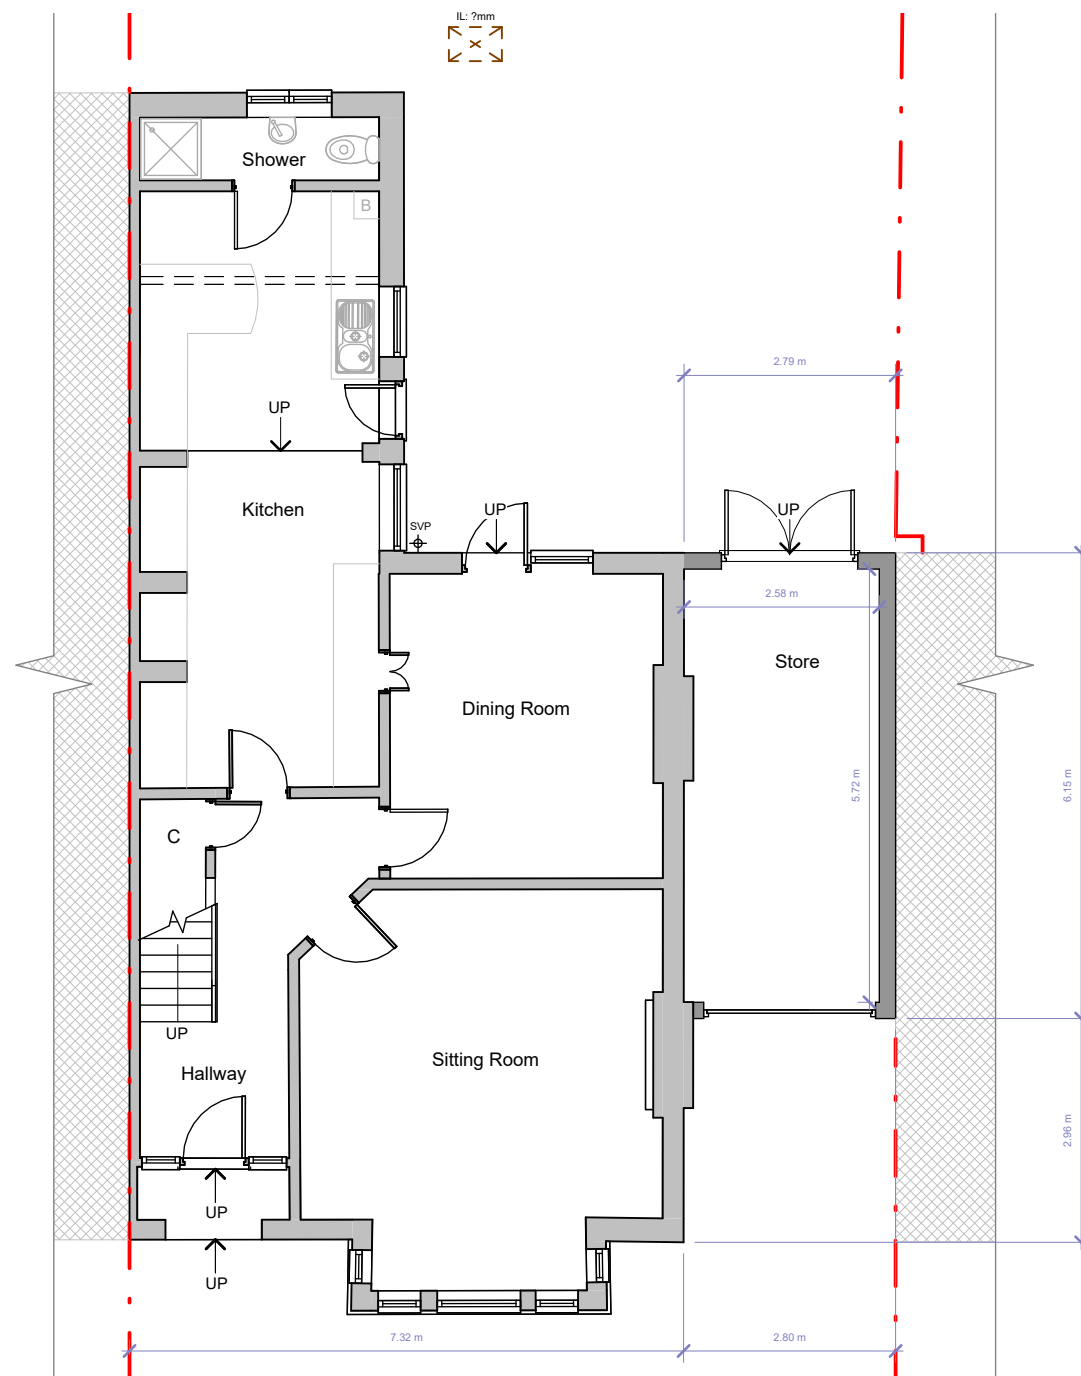

Ground Floor

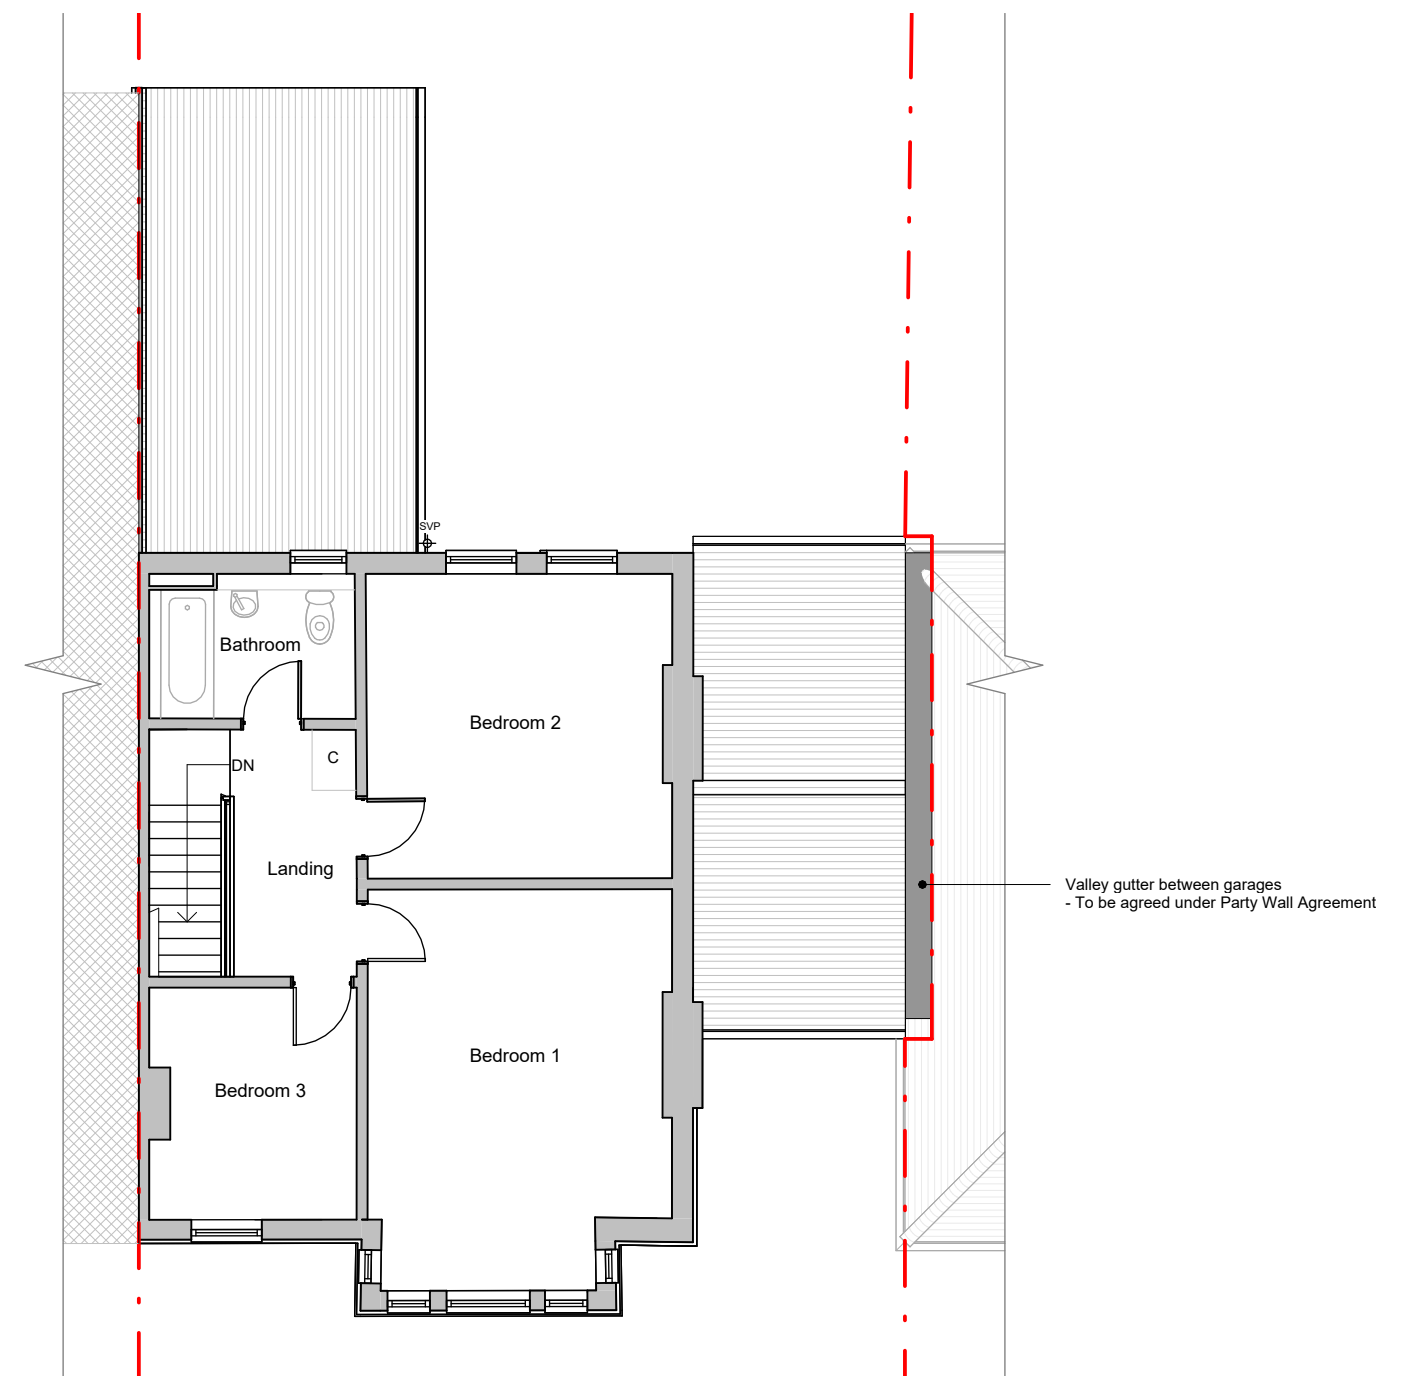

First Floor



FLUENT
ARCHITECTURAL DESIGN SERVICES
TEL: 0800 043 8838
E-MAIL: INFO@FLUENT-ADS.CO.UK
WEB: FLUENT-ADS.CO.UK

20 Harrogate Road Caversham Reading

Proposed Ground and First Floor Plans

Scale @ A3
1 : 100

Date
26.02.26

Drawn by
S.G

 
Drawing number
P.M.500

Project number
2521.01

Rev
E

Key:

Existing Proposed SVP Boundary line
Existing drainage Proposed drainage Overhead



No.	Description	Date
0	First Draft	26.02.26
A	Client's comments (1)	10.03.26
B	Client's comments (2)	11.03.26
C	Client's comments (3)	19.03.26
D	Drawing amended	23.03.26
E	Drawing amended	07.04.26