
 


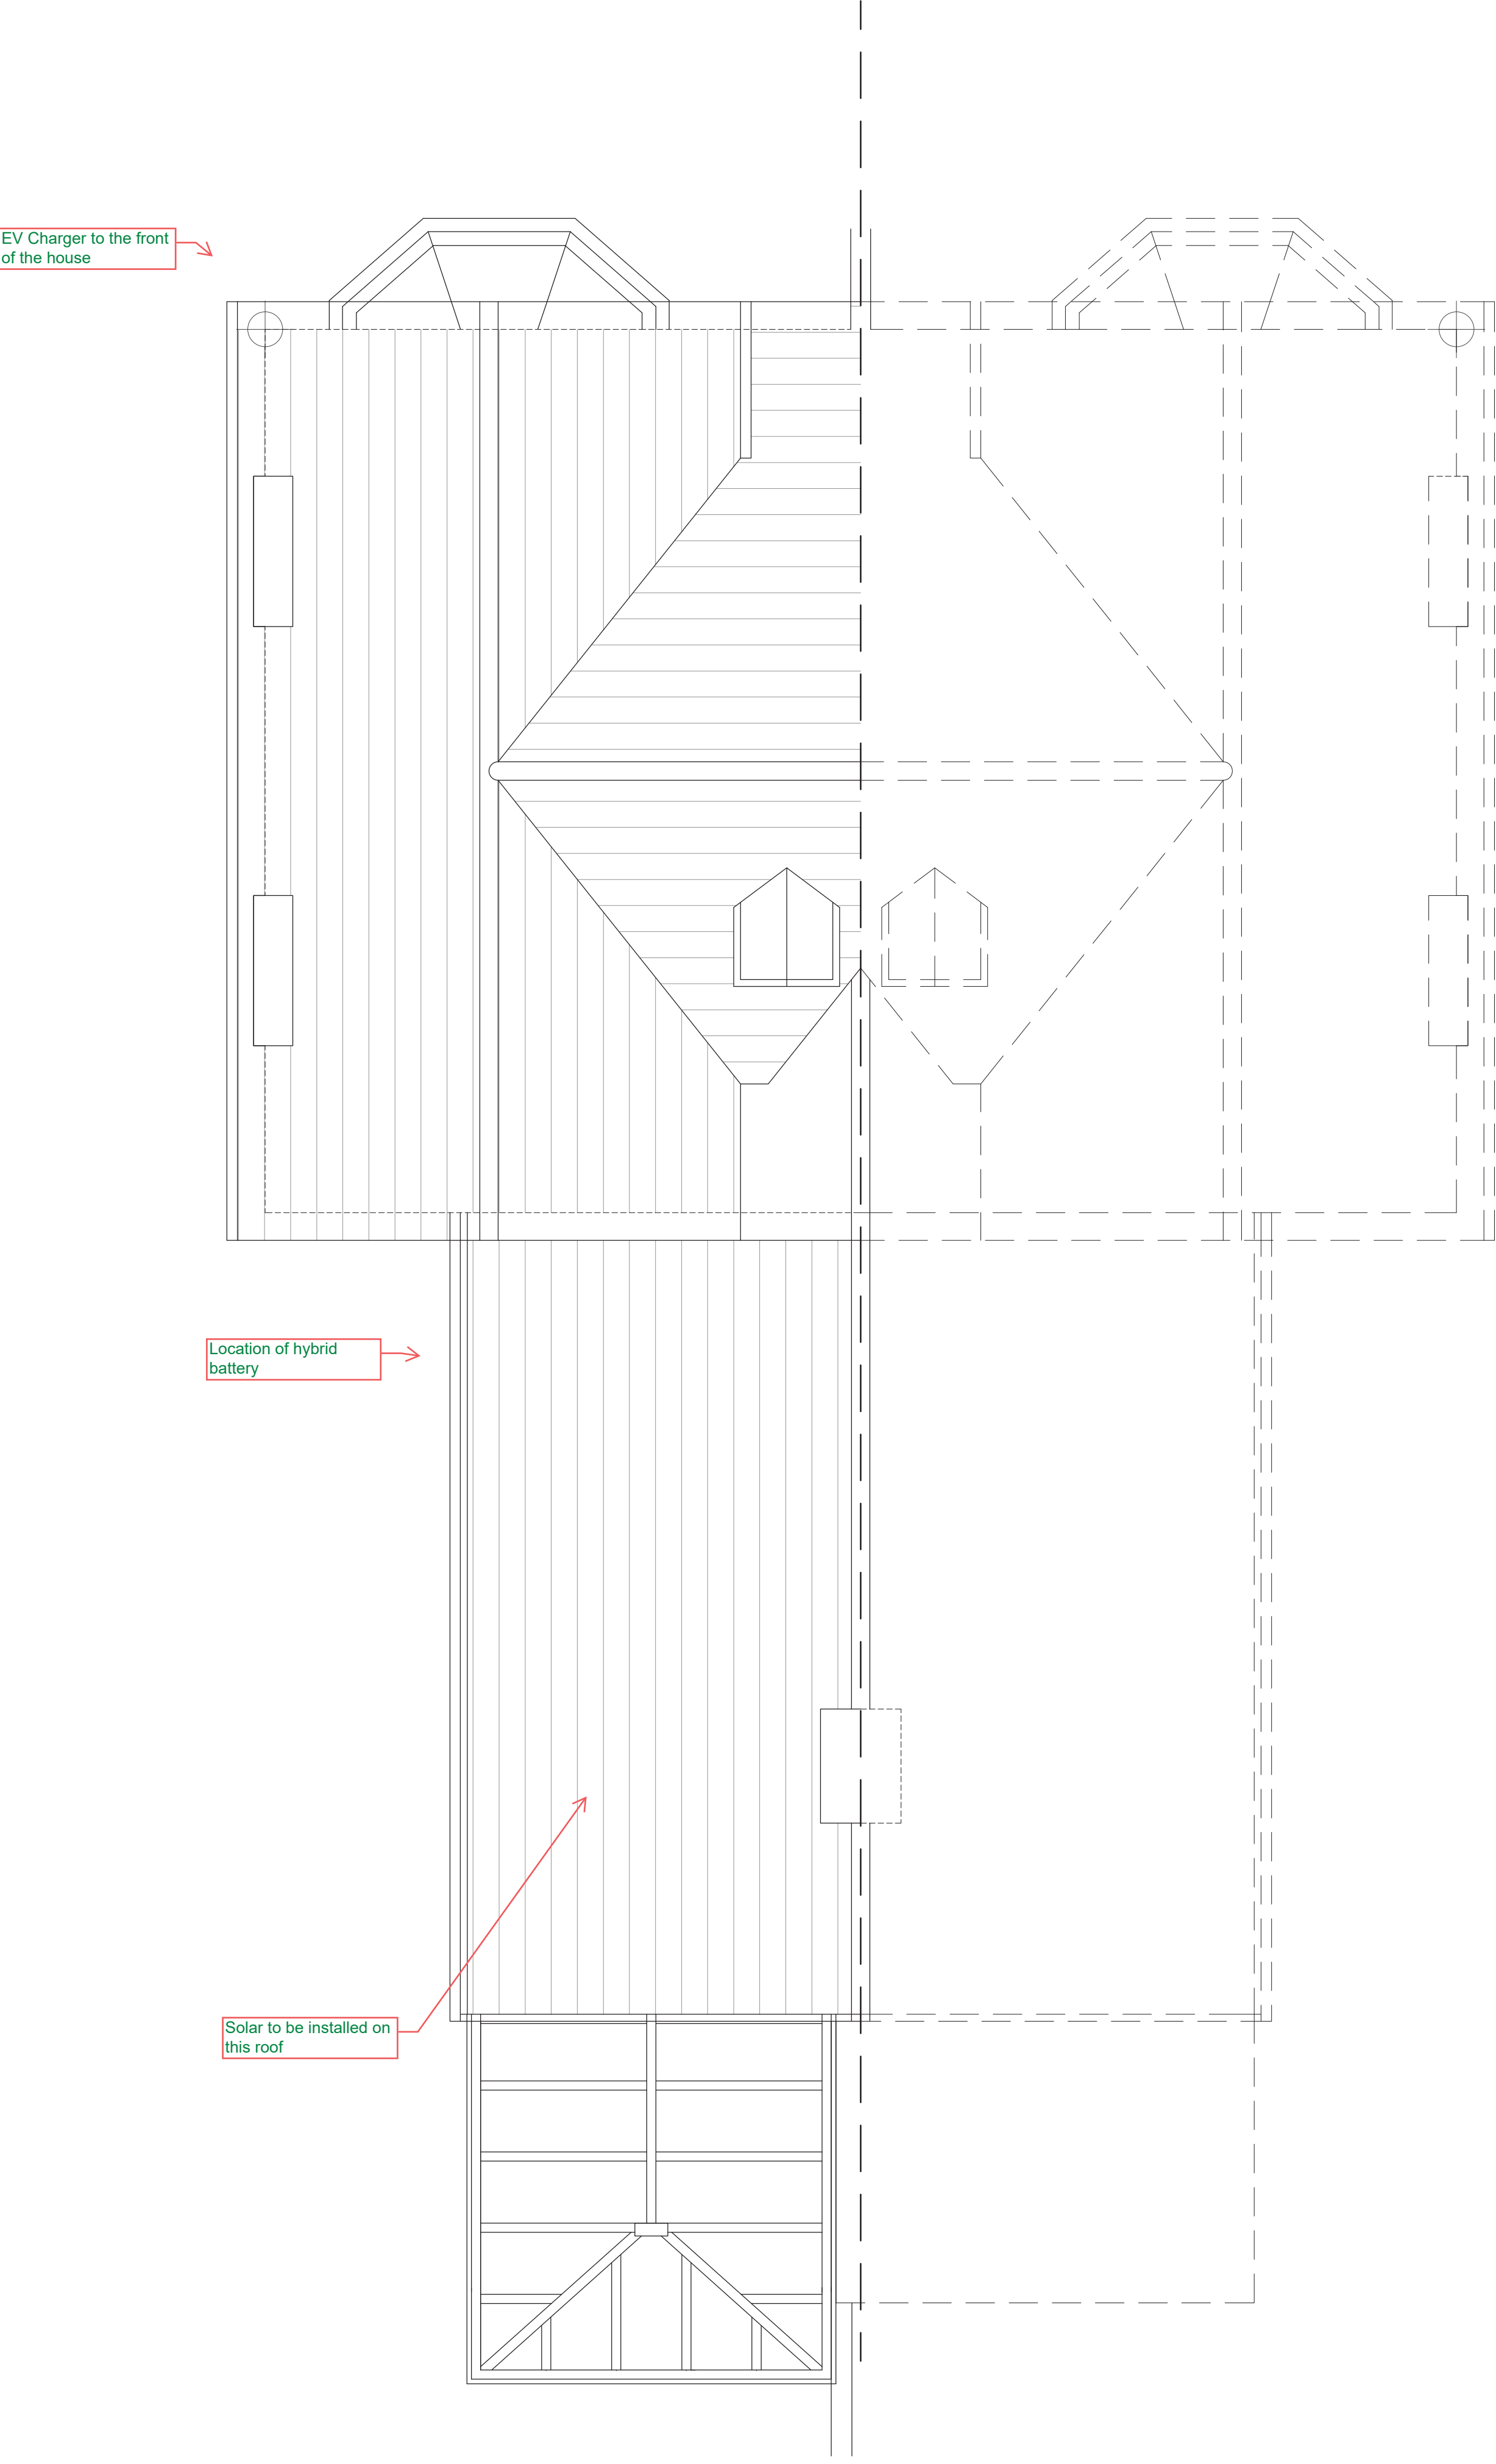

Existing Roof Plan
Scale 1:50



A	23.04.26	JA	DA	JA	ISSUED FOR PLANNING APPROVAL	
REV	DATE	DRN	CHKD	APPD	DESCRIPTION	
DRAWING STATUS						

For Approval



E: info@bluebirdengineering.co.uk
T: 0118 9583 551
A: 46 London Street, Reading, RG1 4SQ

CLIENT
Carter Electrical Installation Ltd

PROJECT
29 Alexandra Road
Reading

TITLE
Existing
Roof Plan

DRAWN JA	DATE April 26	SCALE 1:50 @ A1
-------------	------------------	--------------------

DRG NO A-1010	REV A
------------------	----------