


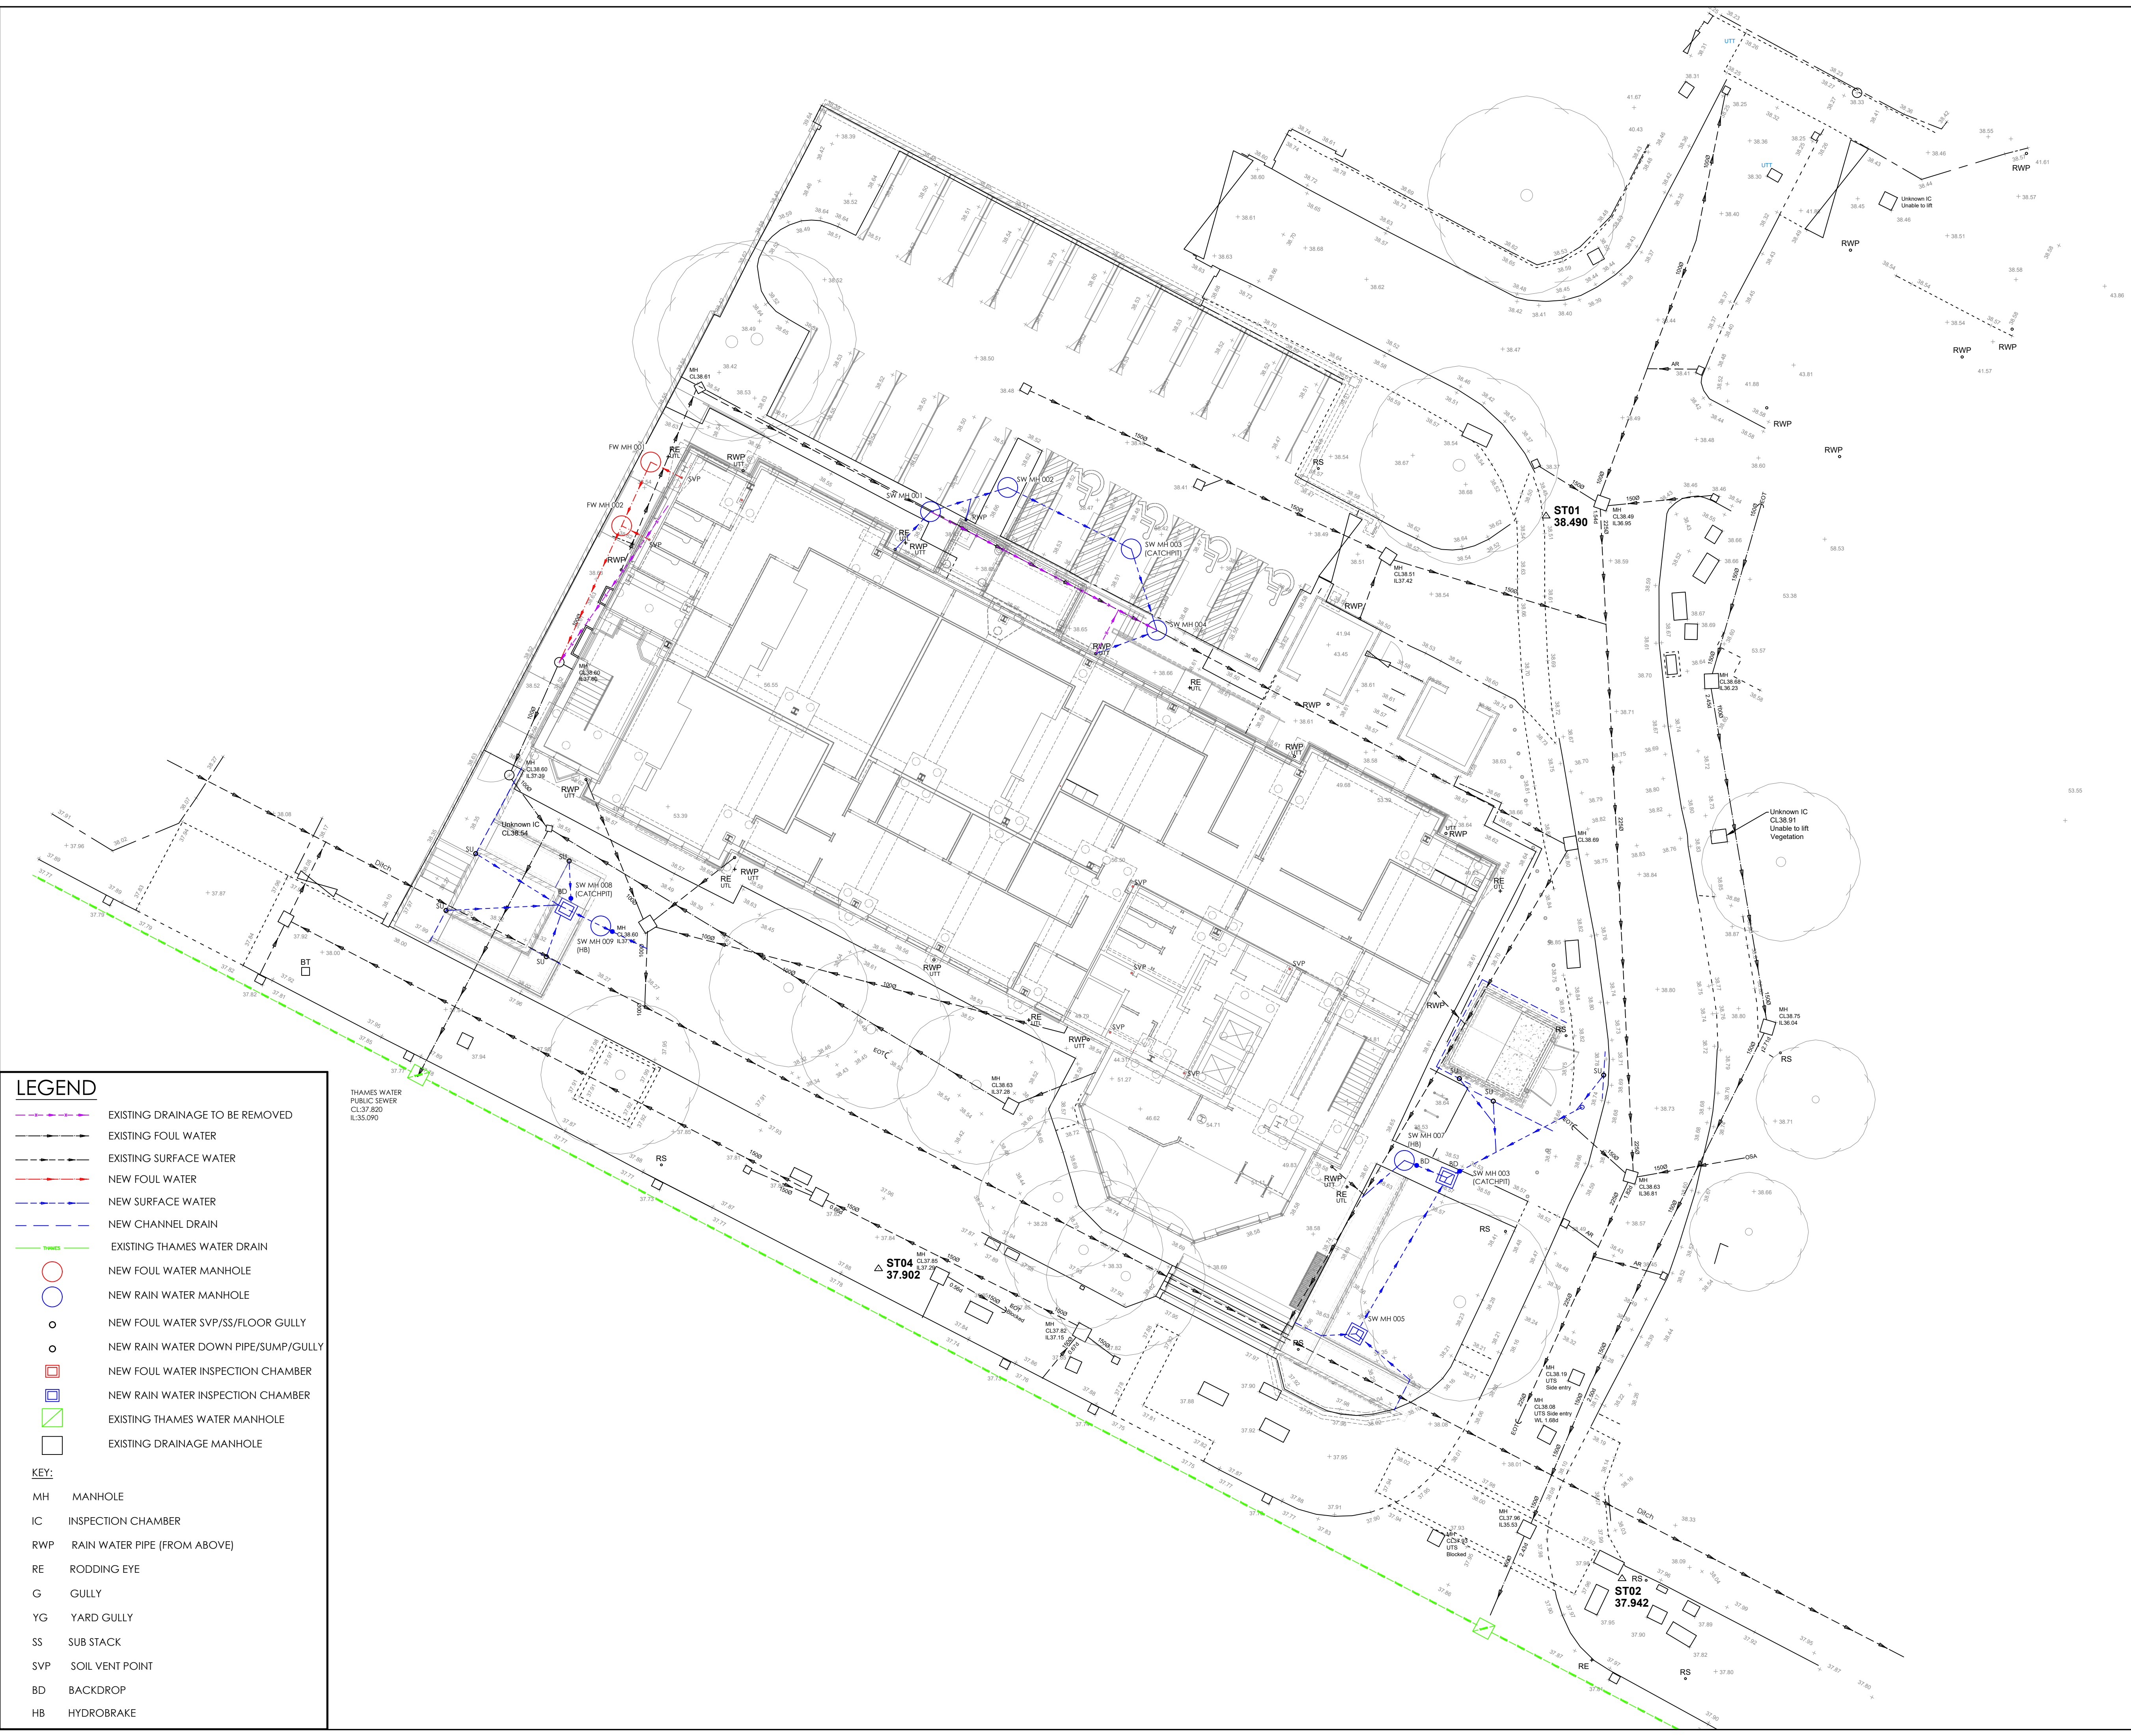

LEGEND

EXISTING DRAINAGE TO BE REMOVED

EXISTING FOUL WATER

EXISTING SURFACE WATER

NEW FOUL WATER

NEW SURFACE WATER

NEW CHANNEL DRAIN

EXISTING THAMES WATER DRAIN

NEW FOUL WATER MANHOLE

NEW RAIN WATER MANHOLE

NEW FOUL WATER SVP/SS/FLOOR GULLY

NEW RAIN WATER DOWN PIPE/SUMP/GULLY

NEW FOUL WATER INSPECTION CHAMBER

NEW RAIN WATER INSPECTION CHAMBER

EXISTING THAMES WATER MANHOLE

EXISTING DRAINAGE MANHOLE

KEY:

MH

MANHOLE

IC

INSPECTION CHAMBER

RWP

RAIN WATER PIPE (FROM ABOVE)

RE

RODDING EYE

G

GULLY

YG

YARD GULLY

SS

SUB STACK

SVP

SOIL VENT POINT

BD

BACKDROP

HB

HYDROBRAKE

© Crown copyright 2018

Do not scale from drawings. Verify all dimensions on site prior to construction. This drawing is to be read in conjunction with all relevant documents and drawings. Report all discrepancies to MoJ immediately.

No unauthorised use, disclosure, storage or copying.

Notes

1. All private drainage must comply with the current edition of DMR Building Regulations approved Document H.

2. Where drainage is to be adopted it should meet with the requirements of Sewers for Adoption 7th edition.

3. Drainage design to be to BS EN 1251-1:1996.

4. Any intended changes to the drainage design must be discussed with the Engineer. If changes are made the Engineer must be supplied with as-constructed information to enable drawings to be suitably updated for the Health & Safety file.

5. Before works commence the contractor should satisfy themselves that the details of the drainage system to be connected into are correct i.e. cover, invert levels, line, condition and type of sewer.

6. Private access changes are to be appropriate to the depth and loadings as follows:

Depth to invert

Access via

Up to 400mm

Man access chamber 300mmØ

Up to 1200mm

Inspection chamber 475mmØ (PPHC) 400mmØ 40mm brick/P.C.C. units

120 to 1500mm

P.C.C. ring manhole 1500mmØ

150 to 3000mm

P.C.C. ring manhole 1200mmØ

(Ring diameter increased if sewer greater than 475mmØ).

7. All manholes and have a flexible joint within 150mm of the face of the structure and a 'rocker joint' which should not exceed 400mm in length.

8. Type material shall be:

Up to 400mm

Unlined

400 to 1500mm

Unlined

1500 to 3000mm

Unlined

Up to 400mm

UPVC - BS EN 1401 PP - BS EN 1882

400 to 1500mm

UPVC - BS EN 1401 PP - BS EN 1882

1500 to 3000mm

UPVC - BS EN 1401 PP - BS EN 1882

9. For private sewers having 900mm or less cover beneath carriageways & hardstanding or 600mm (hardstanding areas) then they shall have concrete surround or slab protection. Slab protection to be 100mm thick C20 concrete slab with mesh reinforcement and a bearing of 150mm each side of the trench. Concrete surround to be 150mm C20 with flexible joint.

10. Trenches within 1.2m of load bearing wall should be filled with concrete of least to the underside of the foundation. Where the distance is more than 1.2m from the foundations the concrete should be taken or least up to a 45 degree line from the bottom of the foundations. Alternatively, the foundations could be raised to a higher level to avoid undermining by the drainage trench (check with the Engineer where this is required).

11. Flow test and surround to be granular Type 5 unless otherwise noted.

12. Paving through walls or foundations should have either an arched or lined opening to give 50mm clearance around the pipe. The opening shall be masked both sides with a rigid non-permeable material or alternatively a short length of pipe may be built in solid if it is connected within 100mm to access pipes (max 400mm long) with flexible joints.

13. Drainage under buildings should be bedded and surrounded by at least 100mm of granular material.

14. Unless otherwise stated on the drawings or in the schedules then all private drainage shall be 100mmØ.

15. All road gully connections to be 150mmØ and surrounded with 150mm C20 concrete surround.

16. Where schemes require soakaway they shall not be positioned closer than 5m from the nearest dwelling or structure. Where solution features can occur in the underlying strata such as chalk then the reference will need to be increased to 10m.

17. New connections to existing public sewers should be carried in accordance with appropriate Access for Public Industry Act connection consent and also under the supervision of the Water Authority.

18. Cover shall be to BS EN 124:1994

19. Class A1.5 - areas where only pedestrians have access.

20. Class B1.5 - for use in car parks and pedestrian areas where occasional vehicular access is likely.

21. Class C2.0 - areas where not extending more than 500mm from kerb face into the carriageway.

22. Class D4.0 - areas where cars and lorries have access including carparks, hard shoulders, cover and frames to be 150mm deep except resurfaced cut-decks.

23. It is recommended that drainage works should be constructed from the outfall particularly where the outfall depth is relatively shallow. If it is not possible to commence works from the outfall the contractor should satisfy themselves that the invert, line, position and type of existing outfall are correct.

24. Drainage works should be protected from possible damage by construction traffic loading during the construction period. Protection may be provided by barriers. Materials should not be stored during drainage works.

25. Buildings up to 3 storeys shall have a red band of the base of the soil stock 400mm min below the level of the lowest incoming drain. Buildings over 3 storeys must be a minimum of 200mm below the lowest incoming drain. Buildings over 5 storeys then the ground floor drainage connectors should have their own connections to the external drain.

26. Where piling works are undertaken the positions of existing sewers must be accurately located before piling takes place.

P01

24.04.26

For Information

Rev

Date

Description

Key Plan

Project Status

RIBA Stage 4

Client

Project

Reading Tribunal Court

Ministry of Justice, 102 Petty France, London, SW1H 9AJ

Project Description / Site

Reading Tribunal Court

Project Address

Sovereign House
Vastern Rd, Reading RG1 8BT

Building Type

Court

Drawing Title

Combined Drainage Layout

Originator Logo

Drawn By AD Date 15/04/26

Checked By NL Date 15/04/26

Approved By GP Date 15/04/26

Drawing Number

377915_15380-CSD-RTC-ZZ-D-C-0001

Sheet No. 1 of 1

Scale 1:150

Orig. Sheet Size @ A1

Rev. P01

Data Security Classification

OFFICIAL

Suitability

S2

377915_15380-CSD-RTC-ZZ-D-C-0001